


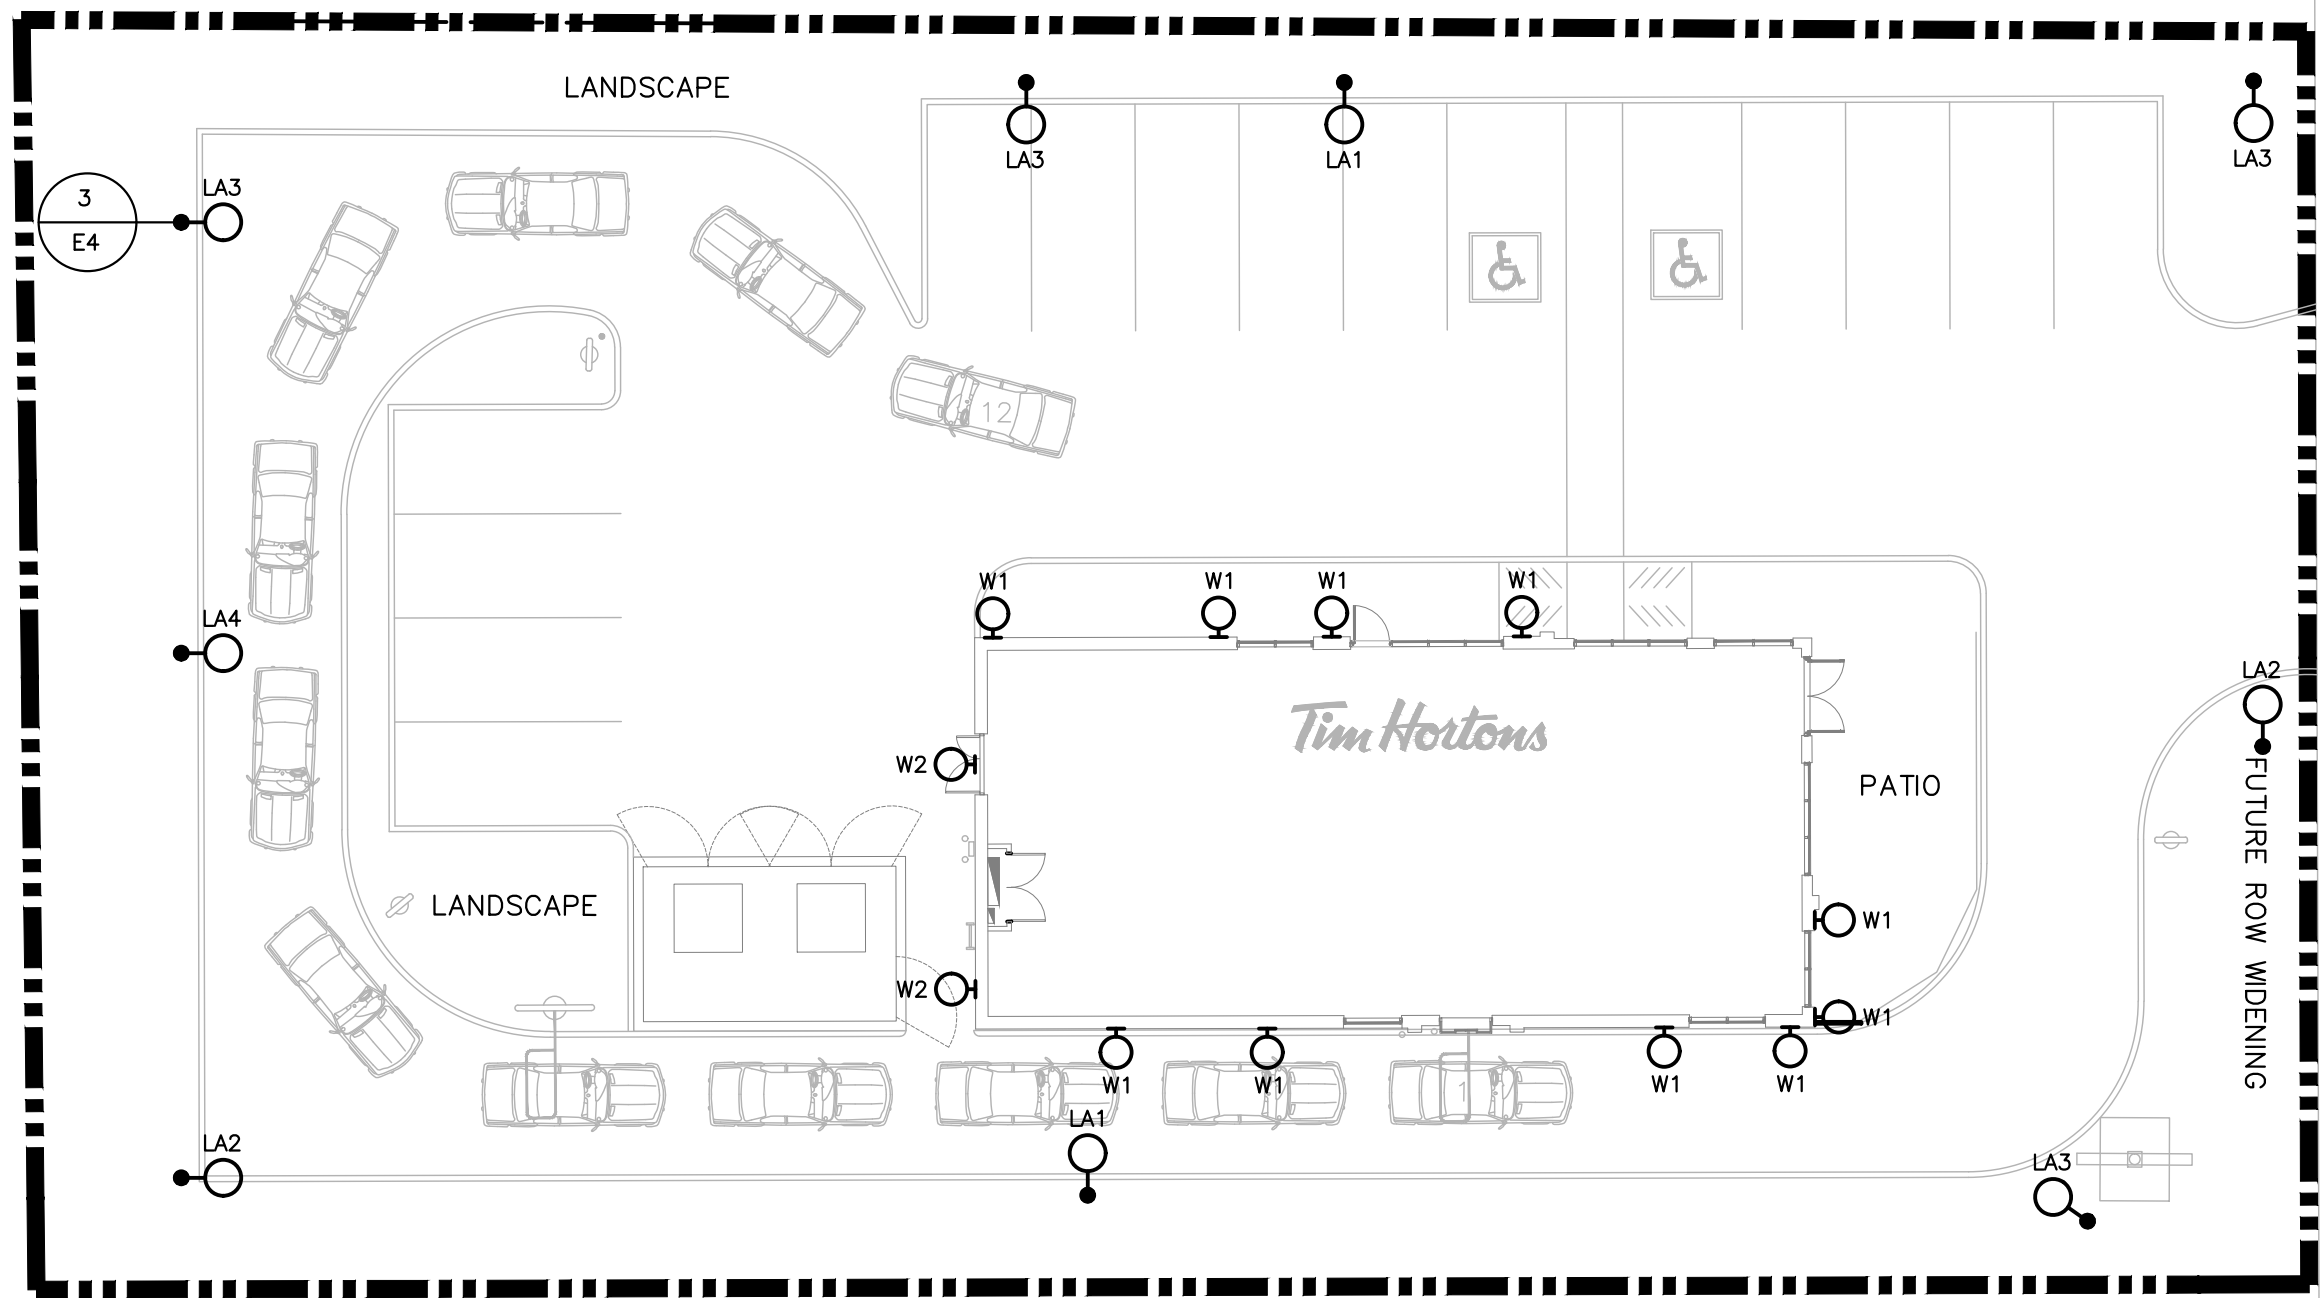

AIRPORT ROAD

Conditions of Use

Verify elevations and/or dimensions on drawing prior to use.
Report any discrepancies to Dillon Consulting Limited.

Do not scale dimensions from drawing.

Do not modify drawing, re-use it, or use it for purposes other
than those intended at the time of its preparation without prior
written permission from Dillon Consulting Limited.



THE TDL GROUP CORP.
HEAD OFFICE
226 WYECROFT ROAD
OAKVILLE, ON
L6K 3X7
Ph (905) 339-6115
Fax (905) 845-1536



CONSULTING ENGINEERS
LIGHTING - ELECTRICAL
506 CITYVIEW BLVD., SUITE 304/305
VAUGHAN, ONTARIO, CANADA L4H 3M7
Tel: (905) 417-4801 Fax: (905) 417-0806
www.dillon.ca



No.	ISSUED FOR S.P.A.	12/18/2019	D.M.
No.	ISSUED FOR	DATE	BY


DESIGN	DM	REVIEWED BY	DM
DRAWN	JK	CHECKED BY	DM
DATE	July 2019	SCALE	1:200

16054 & 16060 Airport Road, Caledon, ON
Store #10XXXX

Tim Hortons
Lighting Site Plan

PROJECT NO.
19-306

SHEET NO.
E1

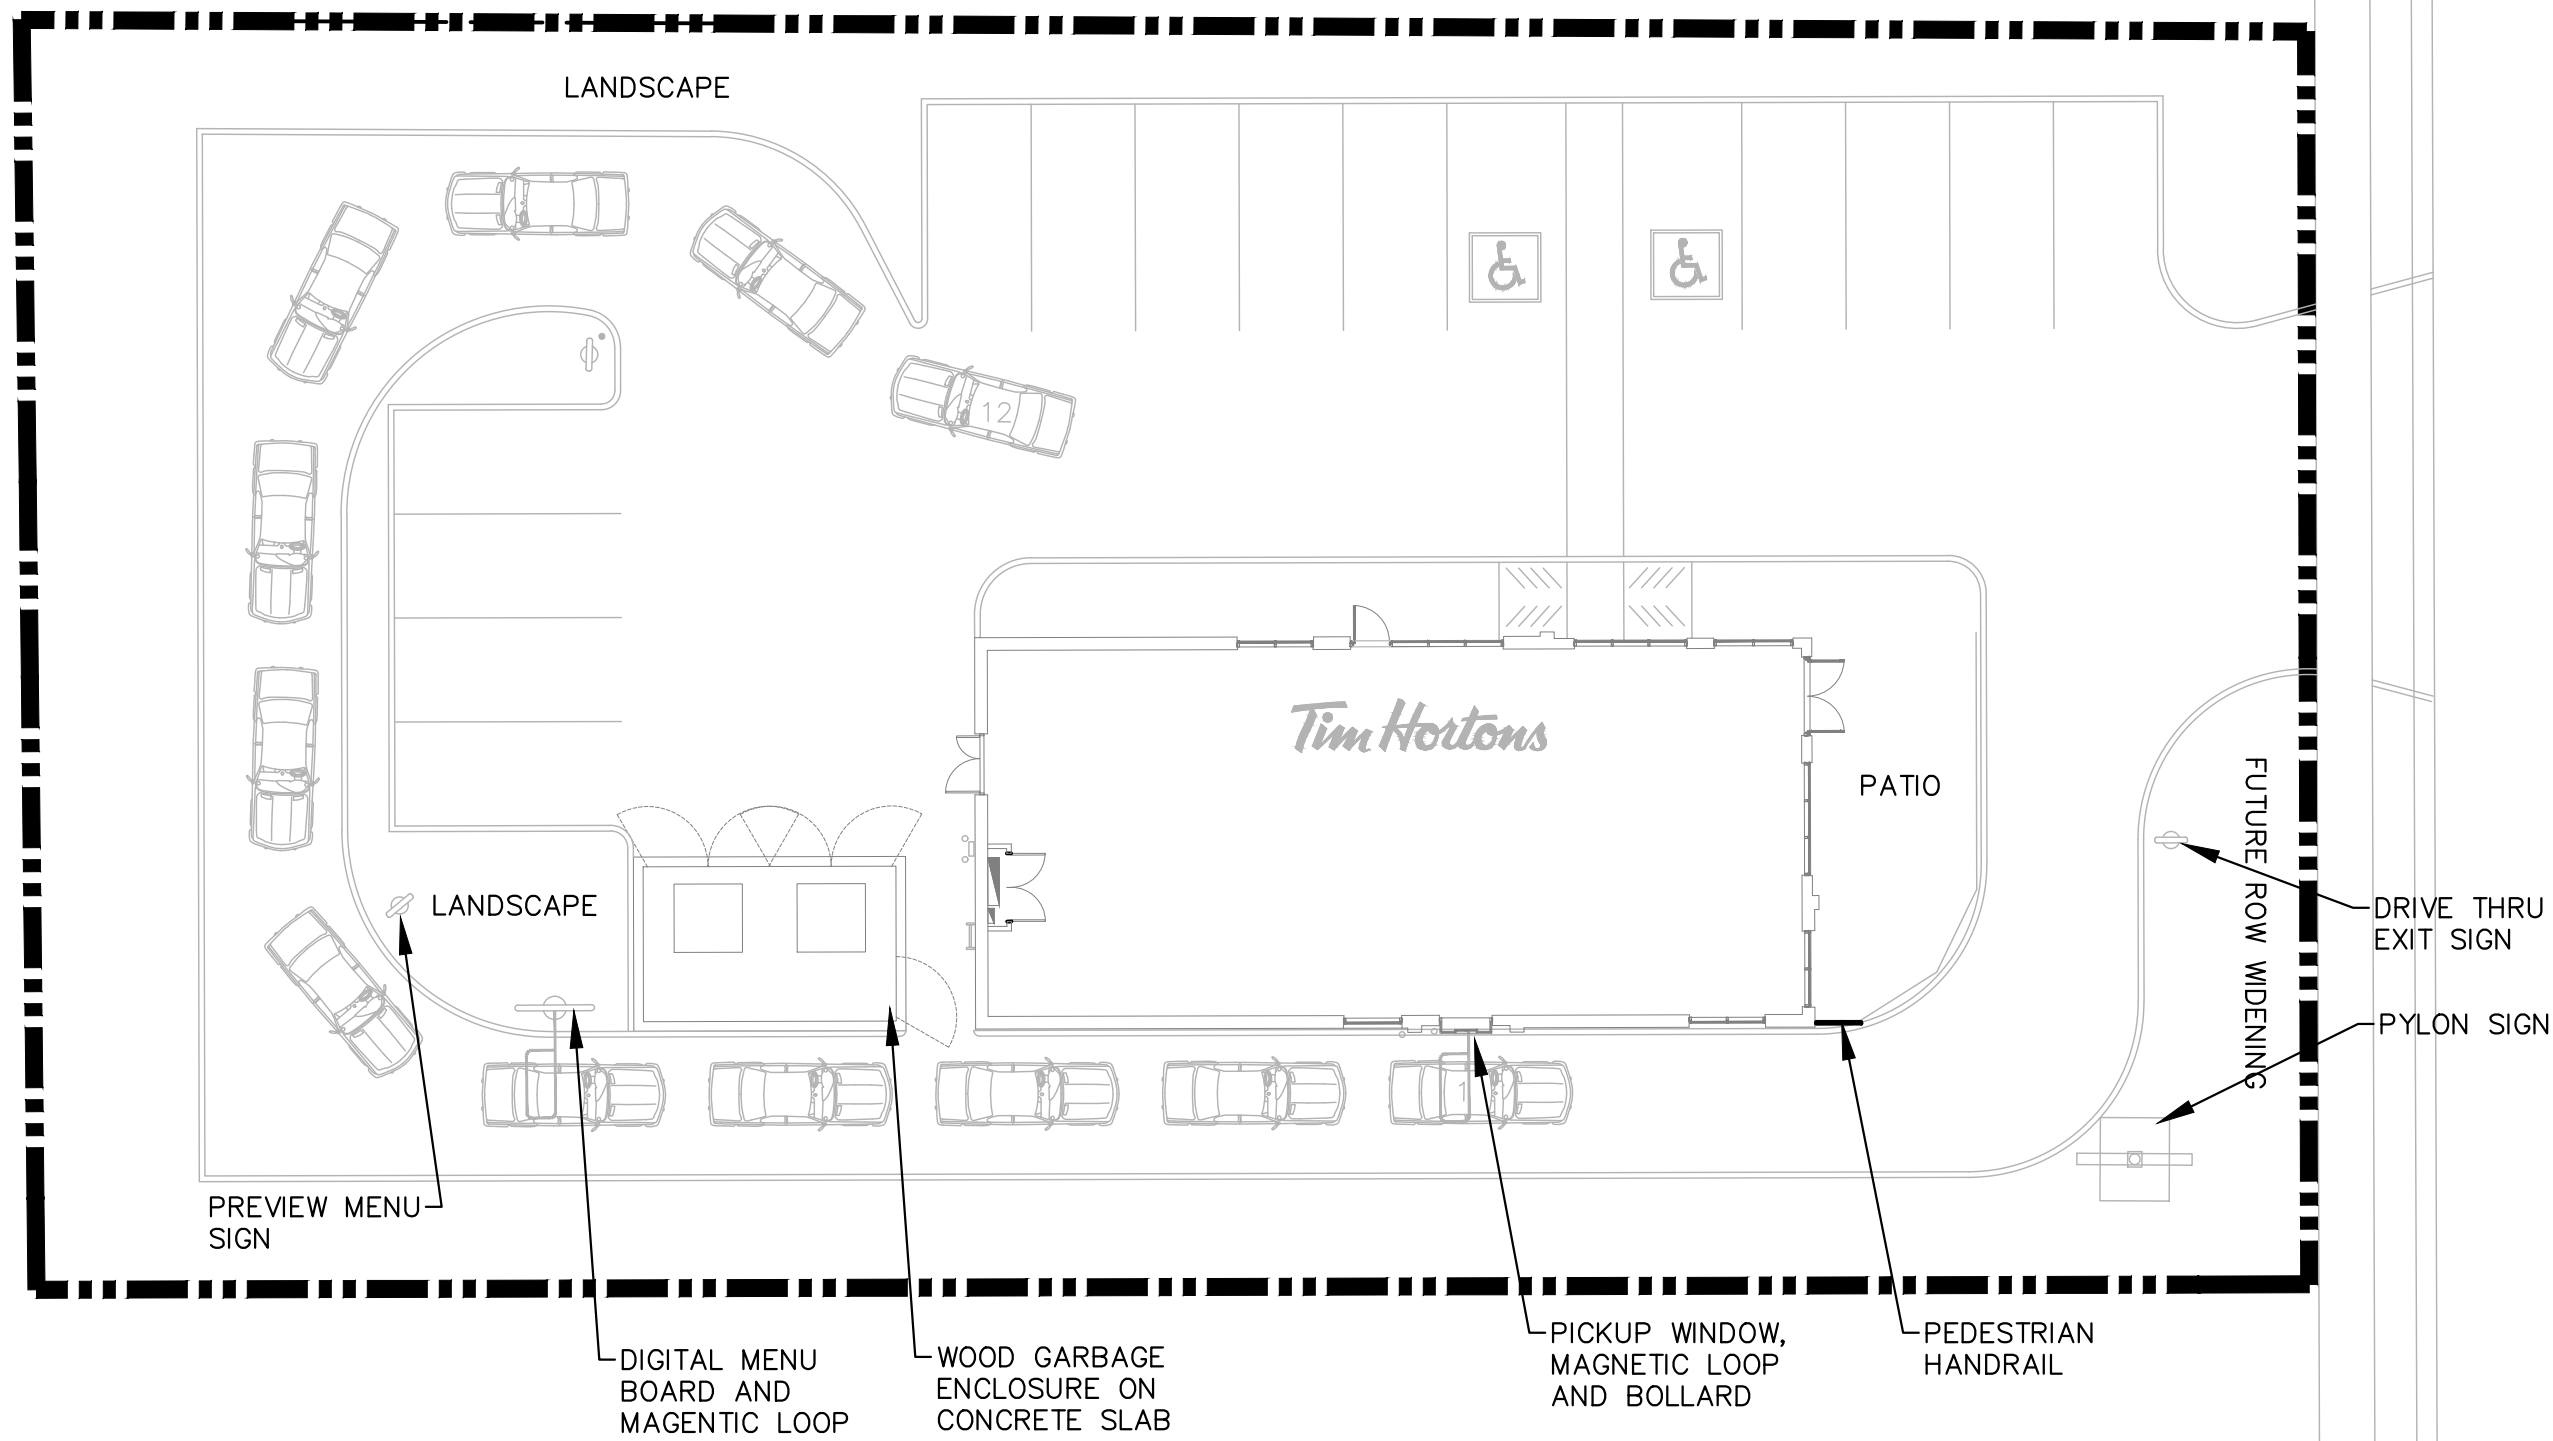


Conditions of Use

Verify elevations and/or dimensions on drawing prior to use.
Report any discrepancies to Dillon Consulting Limited.

Do not scale dimensions from drawing.

Do not modify drawing, re-use it, or use it for purposes other than those intended at the time of its preparation without prior written permission from Dillon Consulting Limited.

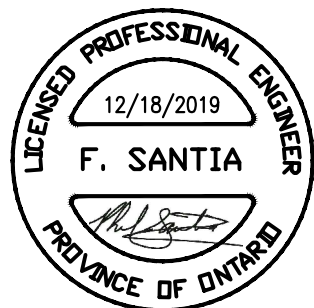

THE TDL GROUP CORP.
HEAD OFFICE
226 WYECROFT ROAD
OAKVILLE, ON
L6K 3X7
Ph (905) 339-6115
Fax (905) 845-1536



CONSULTING ENGINEERS
LIGHTING - ELECTRICAL
506 CITYVIEW BLVD., SUITE 304/305
VAUGHAN, ONTARIO, CANADA L4H 3K7
Tel: (905) 417-4801 Fax: (905) 417-0856
www.e-tim Hortons.ca



1	ISSUED FOR S.P.A.	12/18/2019	D.M.
No.	ISSUED FOR	DATE	BY

DESIGN	DM	REVIEWED BY	DM
DRAWN	JK	CHECKED BY	DM
DATE	July 2019		
SCALE	1:200		

16054 & 16060 Airport Road, Caledon, ON
Store #10XXXX

Tim Hortons
Electrical Site Plan

PROJECT NO.
19-306

SHEET NO.
E2

1. PROVIDE ALL WORK ASSOCIATED WITH THIS DETAIL. FINISH TO SUIT ARCHITECT'S REQUIREMENTS.
2. REFER TO STRUCTURAL DRAWINGS FOR DETAILS OF BASE. THE BASE SHALL BE PROVIDED BY DIVISION 16 IN ACCORDANCE WITH DETAILS OF DIVISION 3.
3. PROVIDE 5" ROUND POLE.



5 LIGHTING ANALYSIS STATS & LUMINAIRE SCHEDULE
E4 SCALE: N.T.S.

[illegible]